

- BOUNDARY
- ELECTRICAL
- HVAC
- AUDIO
- ⊕ LIGHTING
- BREATHER MEMBRANES, DPC & DPM
- VCL

Leonard Rose




PROJECT TITLE
STUDIO & REHERSAL SPACE

CONTRACTOR
 ME

DRAWING TITLE
GENERAL ARRANGEMENT, & SECTIONS

PRELIMINARY

SCALE	1:20	DRAWN BY	LRD
PAPER SIZE	A1	CHECKED BY	LRD
DATE	04.01.2024	REVISION	
PROJECT	SRS-0001		P01
DRAWING NUMBER	SRS-0001-001		

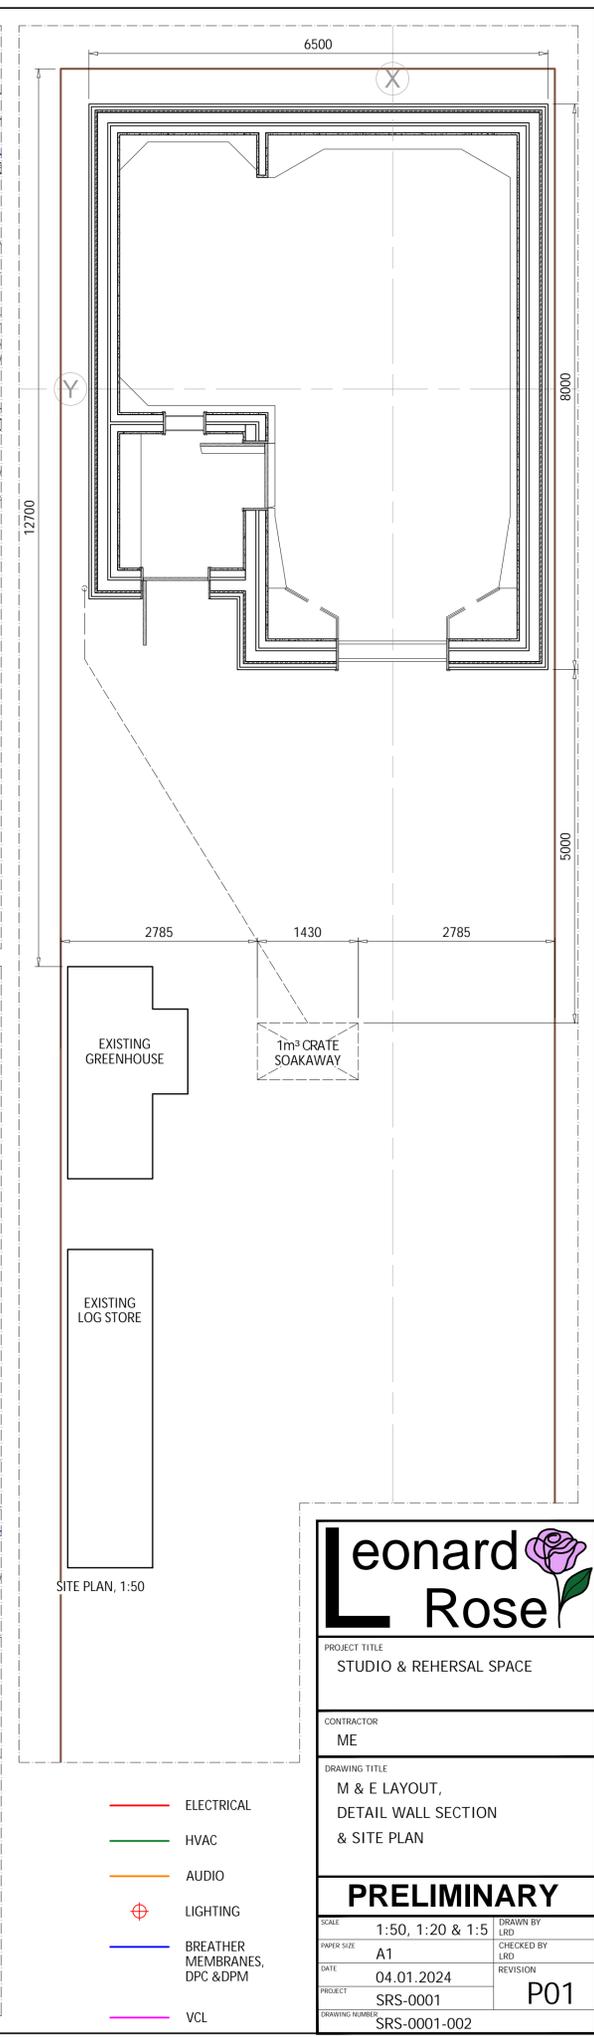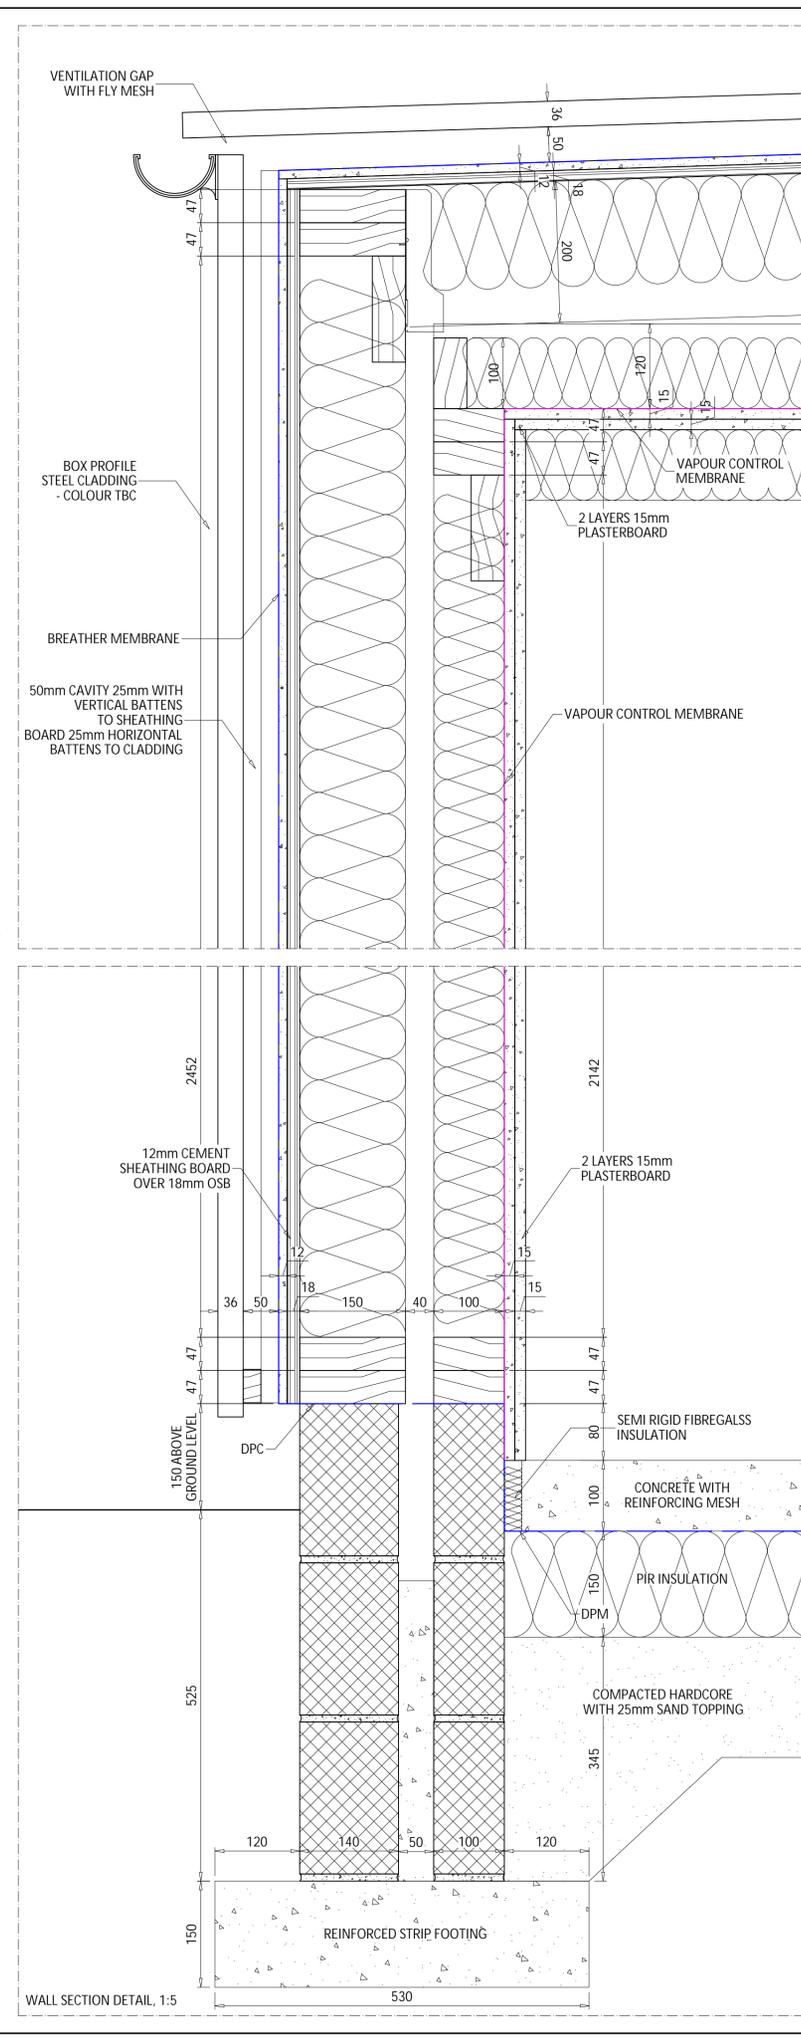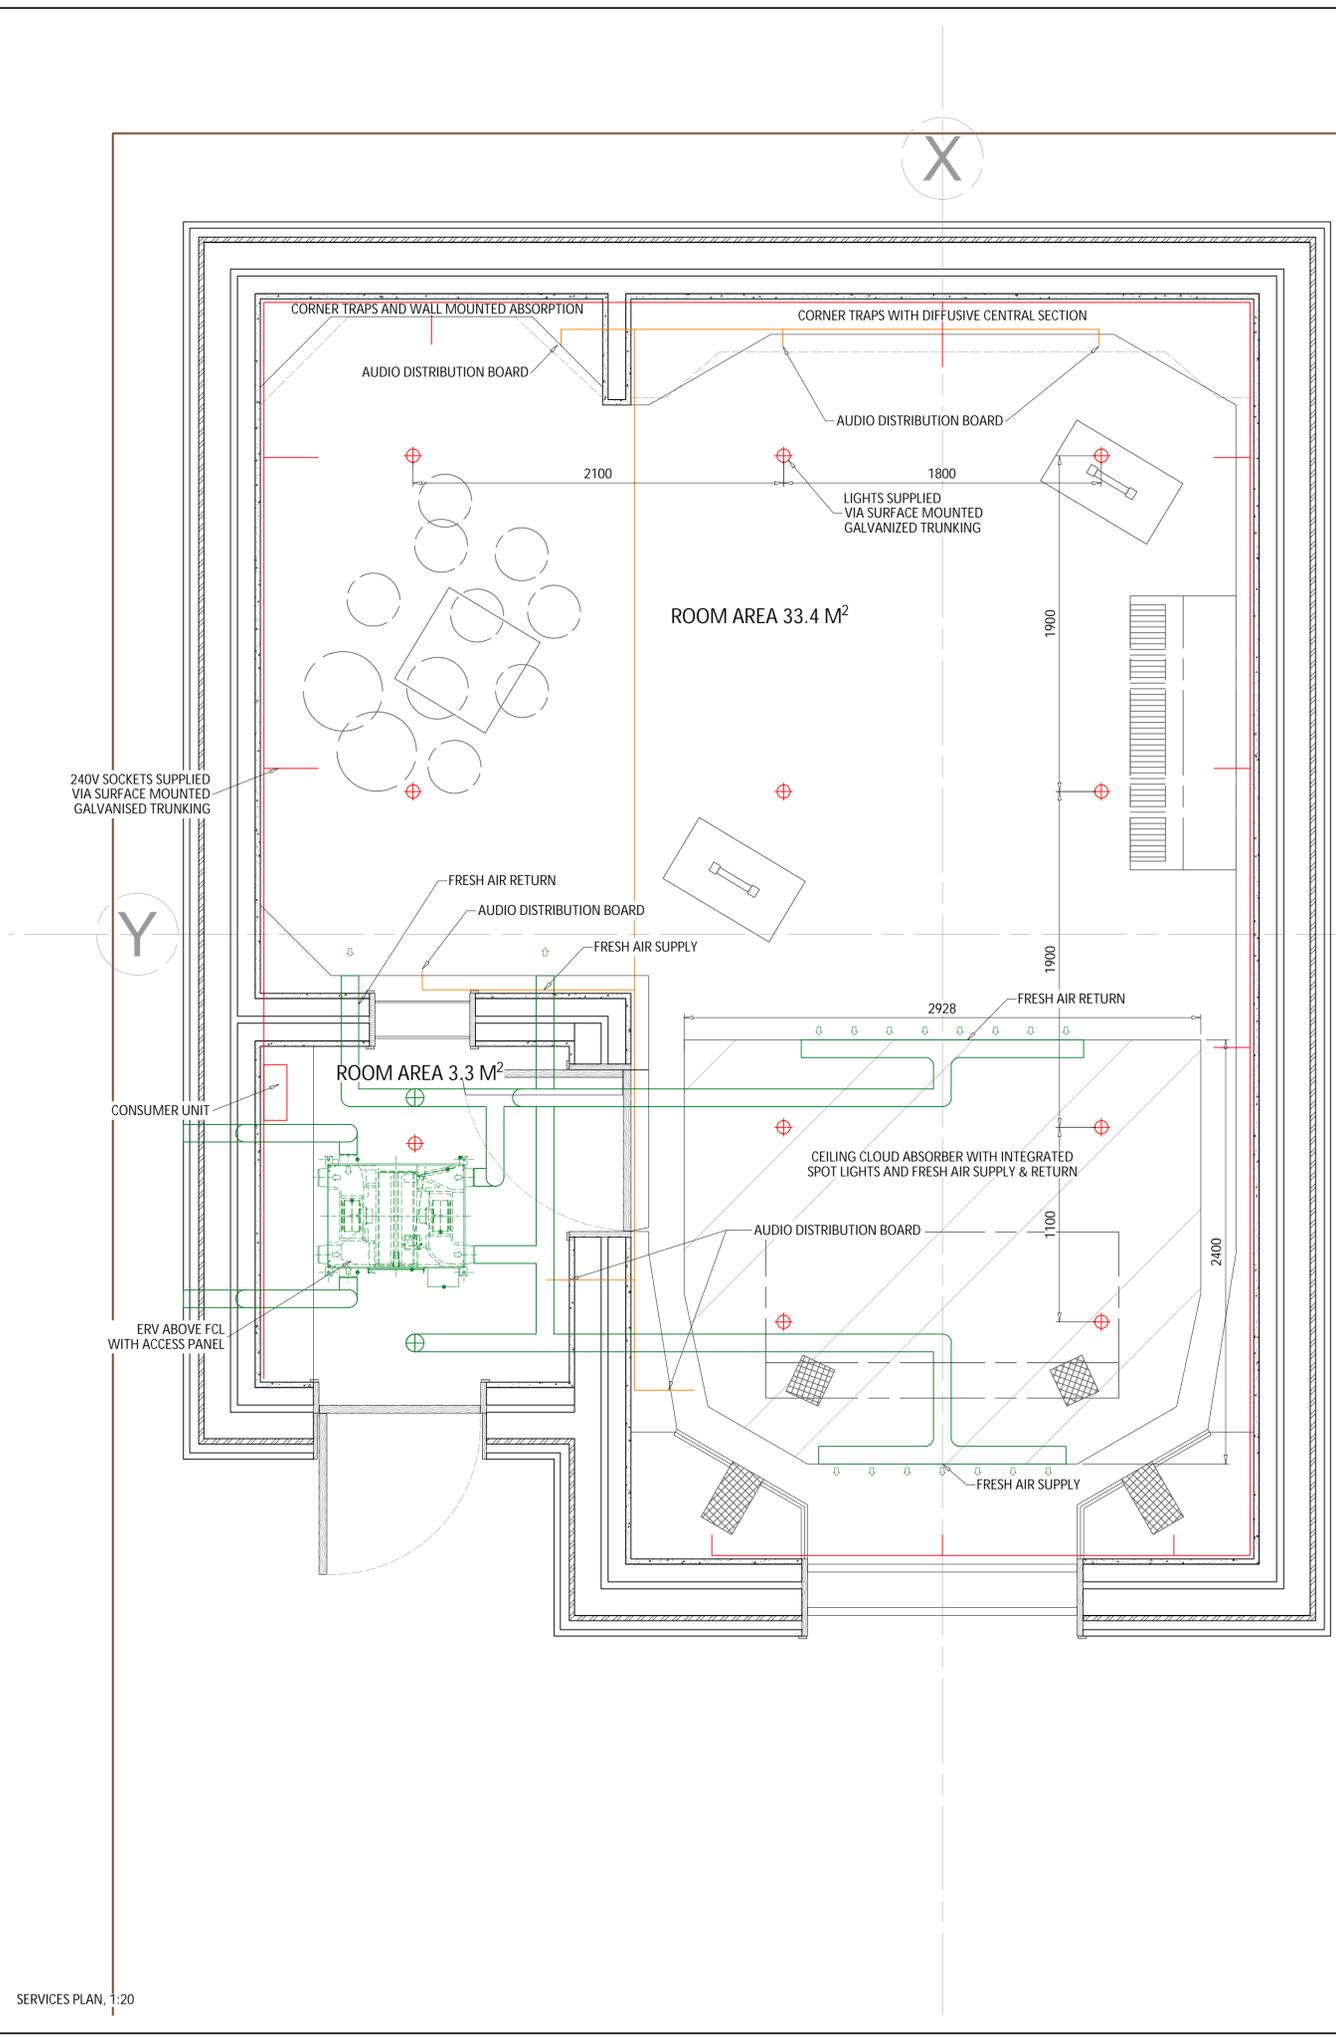

Leonard Rose

PROJECT TITLE
STUDIO & REHERSAL SPACE

CONTRACTOR
ME

DRAWING TITLE
M & E LAYOUT,
DETAIL WALL SECTION
& SITE PLAN

PRELIMINARY

SCALE 1:50, 1:20 & 1:5	DRAWN BY LRD
PAPER SIZE A1	CHECKED BY LRD
DATE 04.01.2024	REVISION
PROJECT SRS-0001	P01
DRAWING NUMBER SRS-0001-002	

- ELECTRICAL
- HVAC
- AUDIO
- ⊕ LIGHTING
- BREATHER MEMBRANES, DPC & DPM
- VCL